

TEXAS REGISTERED ENGINEERING FIRM F-10487 700 N. ST. MARY'S SUITE 1225 SAN ANTONIO, TX 78205 WWW.RGMENGINEERING.NET PHONE: 210.299.4522

FAX: 210.299.4525

DURAND-HOLLIS RUPE ARCHITECTS, INC.

14603 HUEBNER RD.


TEL. 210 308-0080 FAX. 210 697-3309

eMAIL OFFICE@DHRARCHITECTS.COM

BUILDING 18 SAN ANTONIO, TEXAS 78230

PLUMBING FLOOR PLAN


THE SEAL APPEARING ON THIS DOCUMENT WAS AUTHORIZED BY ROGER G. MENDEZ, P.E. 93809 ON 04/01,2016

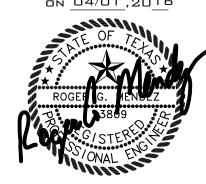


THIS DRAWING IS PROVIDED AS AN INSTRUMENT OF SERVICE BY THE ENGINEER AND IS INTENDED FOR USE ON THIS PROJECT ONLY. THE DRAWING REMAINS THE PROPERTY OF THE ENGINEER AND SHALL BE PETILIPLED TO LINK (USE) REMAINS THE PROPERTY OF THE ENGINEER
AND SHALL BE RETURNED TO HIM/HER
UPON COMPLETION OF THE CONSTRUCTION
WORK. PURSUANT TO THE ENGINEER
WORKS COPYRIGHT PROTECTION ACT OF
1990, ALL DRAWINGS, SPECIFICATIONS,
IDEAS AND DESIGNS, INCLUDING THE
OVERALL FORM, ARRANGEMENT AND
COMPOSITION OF SPACES AND ELEMENTS
APPEARING HEREIN, CONSTITUTES THE
COPYRIGHTED WORK OF THE ENGINEER.
ANY REPRODUCTION, USE, OR DISCLOSURE
OF INFORMATION CONTAINED HEREIN
WITHOUT PRIOR WRITTEN CONSENT OF THE
ENGINEER IS STRICTLY PROHIBITED. © 2015

PROJECT NO. 16-014 ISSUE DATE: 04-01-16 DRAWN BY: REVIEWED BY: RGM PROJECT ARCHITECT: GABRIEL DURAND-HOLLIS, FAIA TEXAS LICENSE NO. 10881

P101

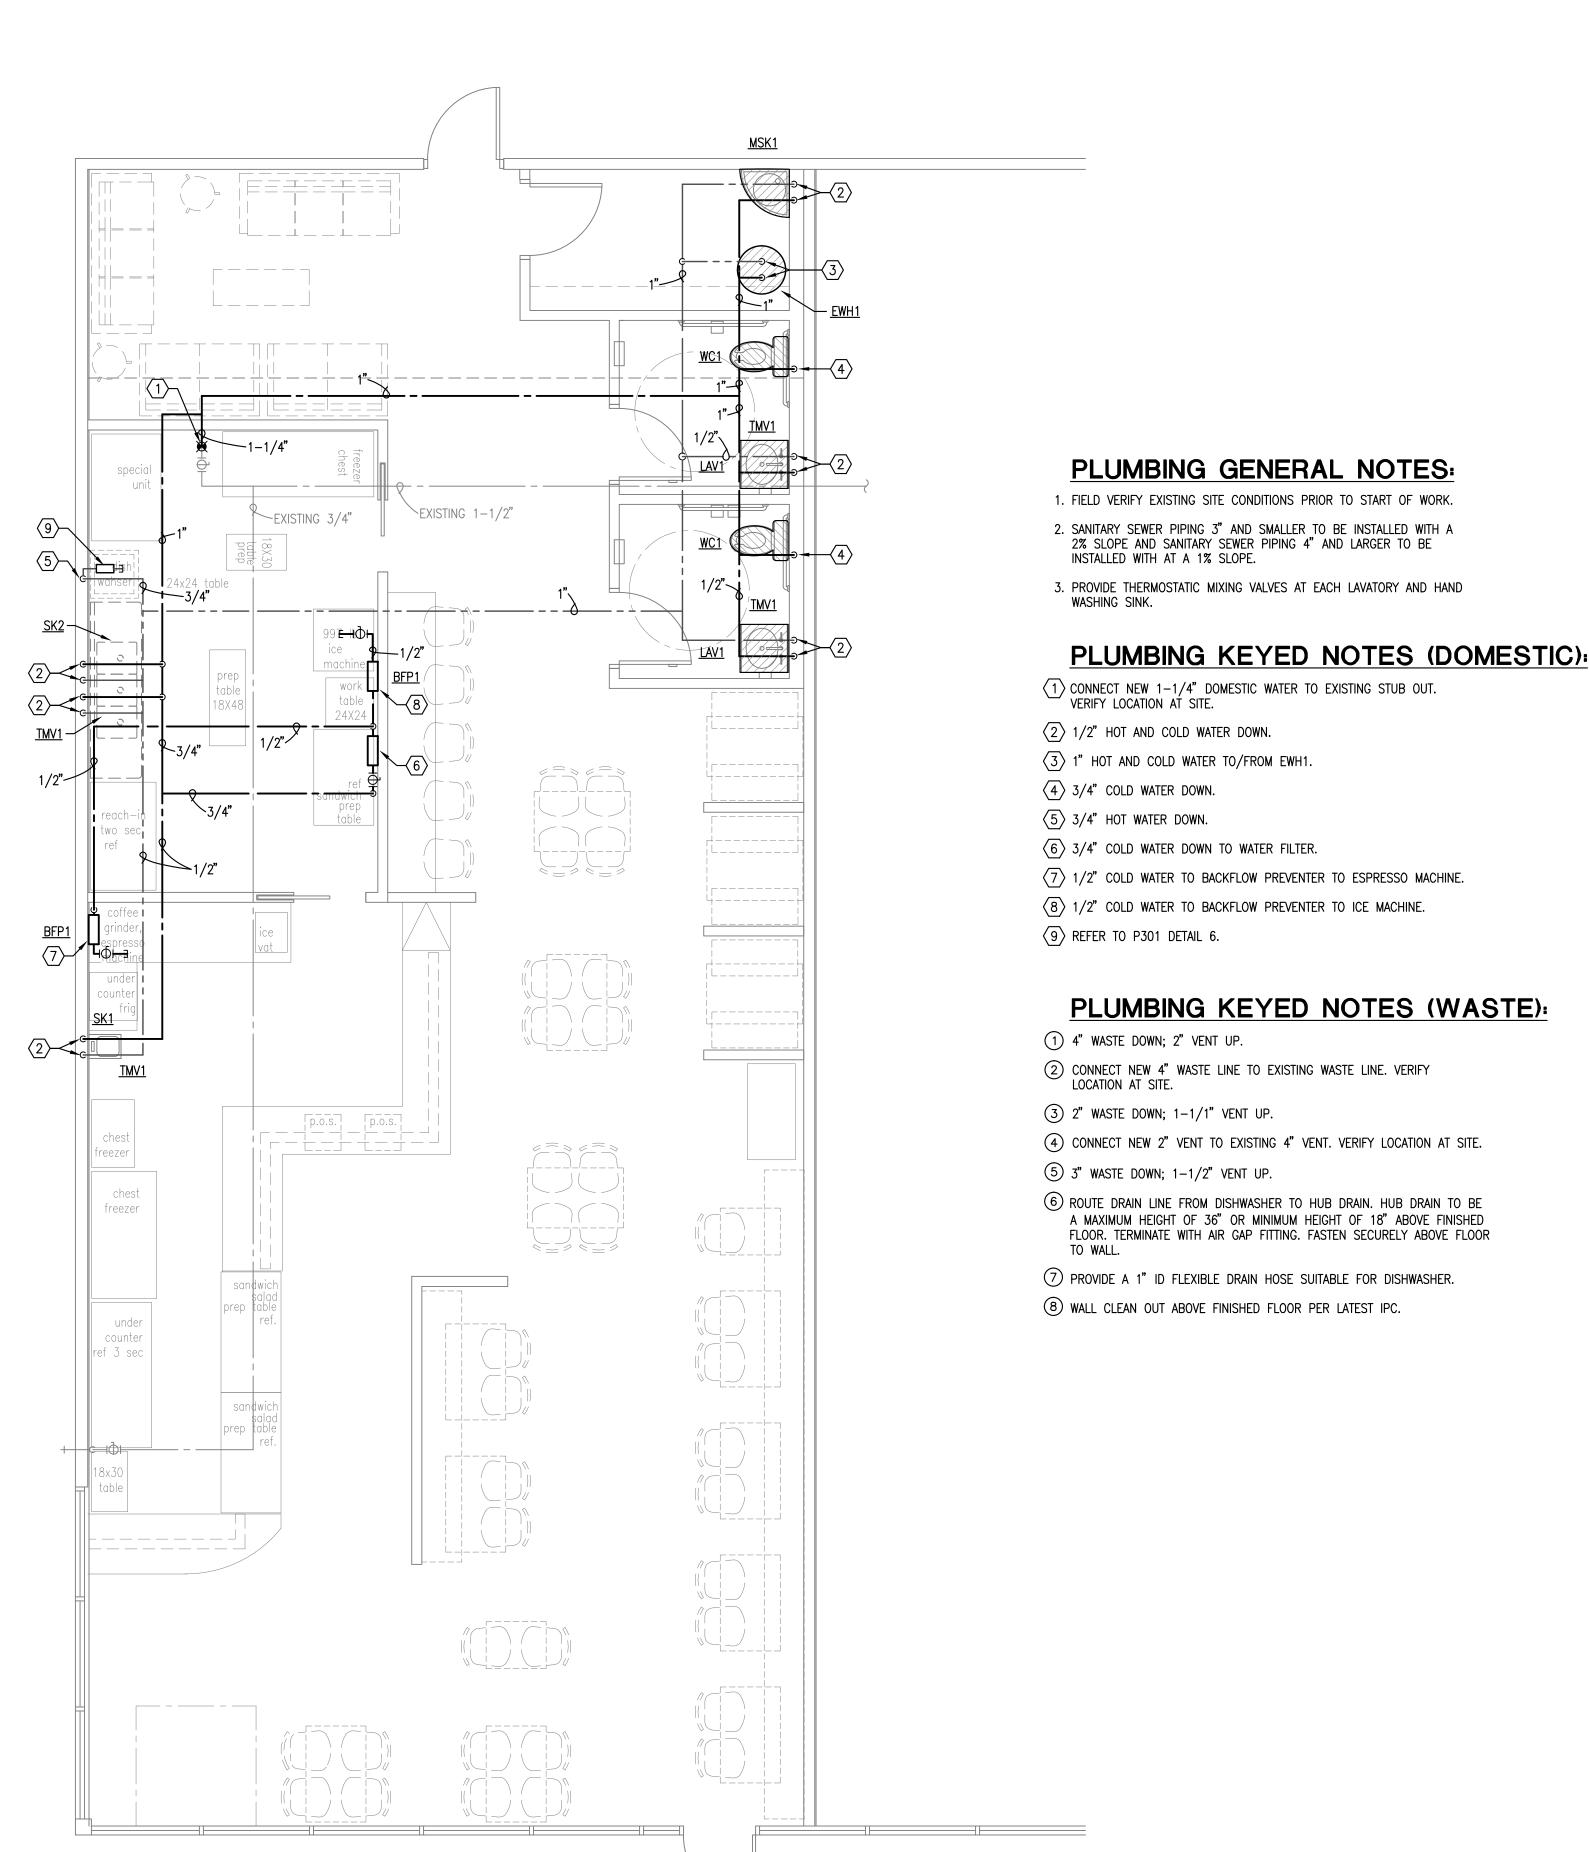

PLUMBING DOMESTIC WATER FLOOR PLAN

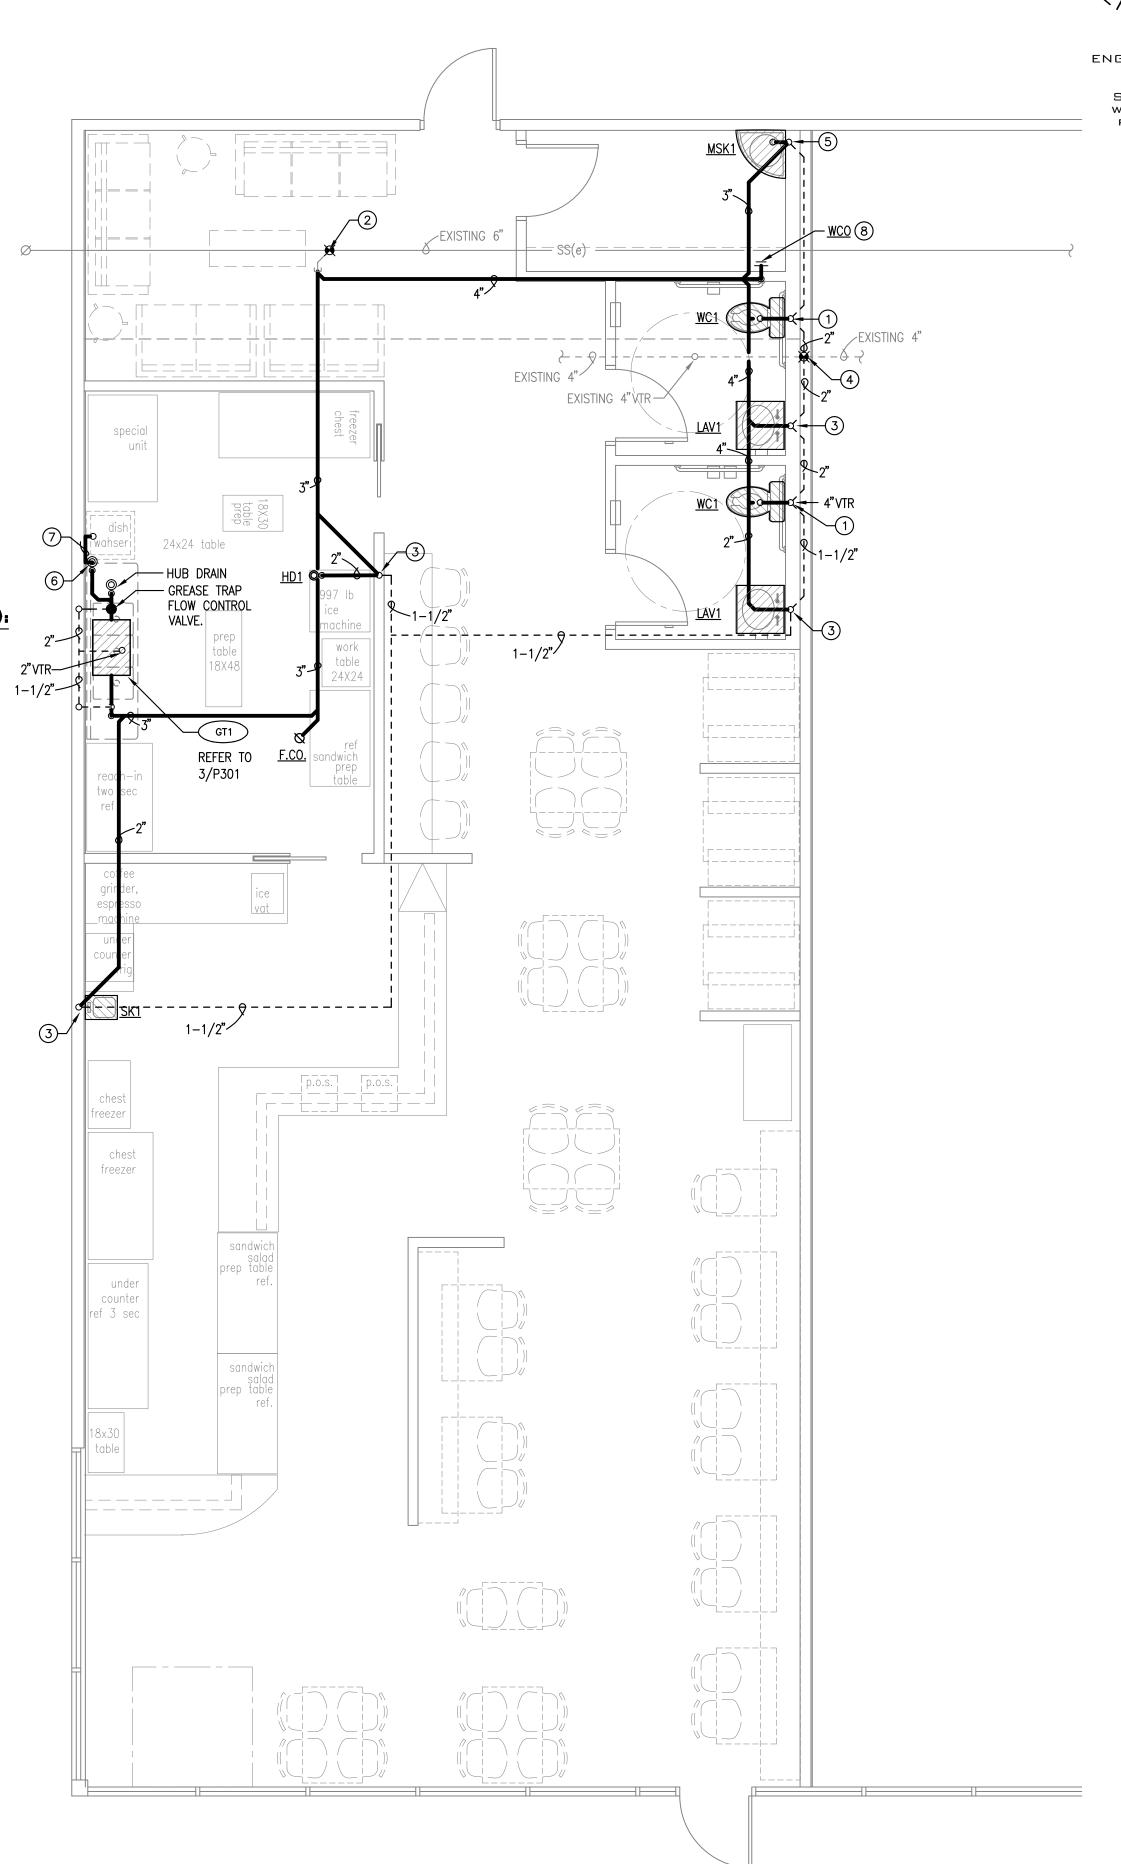

PLUMBING WASTE AND VENT FLOOR PLAN
SCALE: 1/4"=1'-0"